


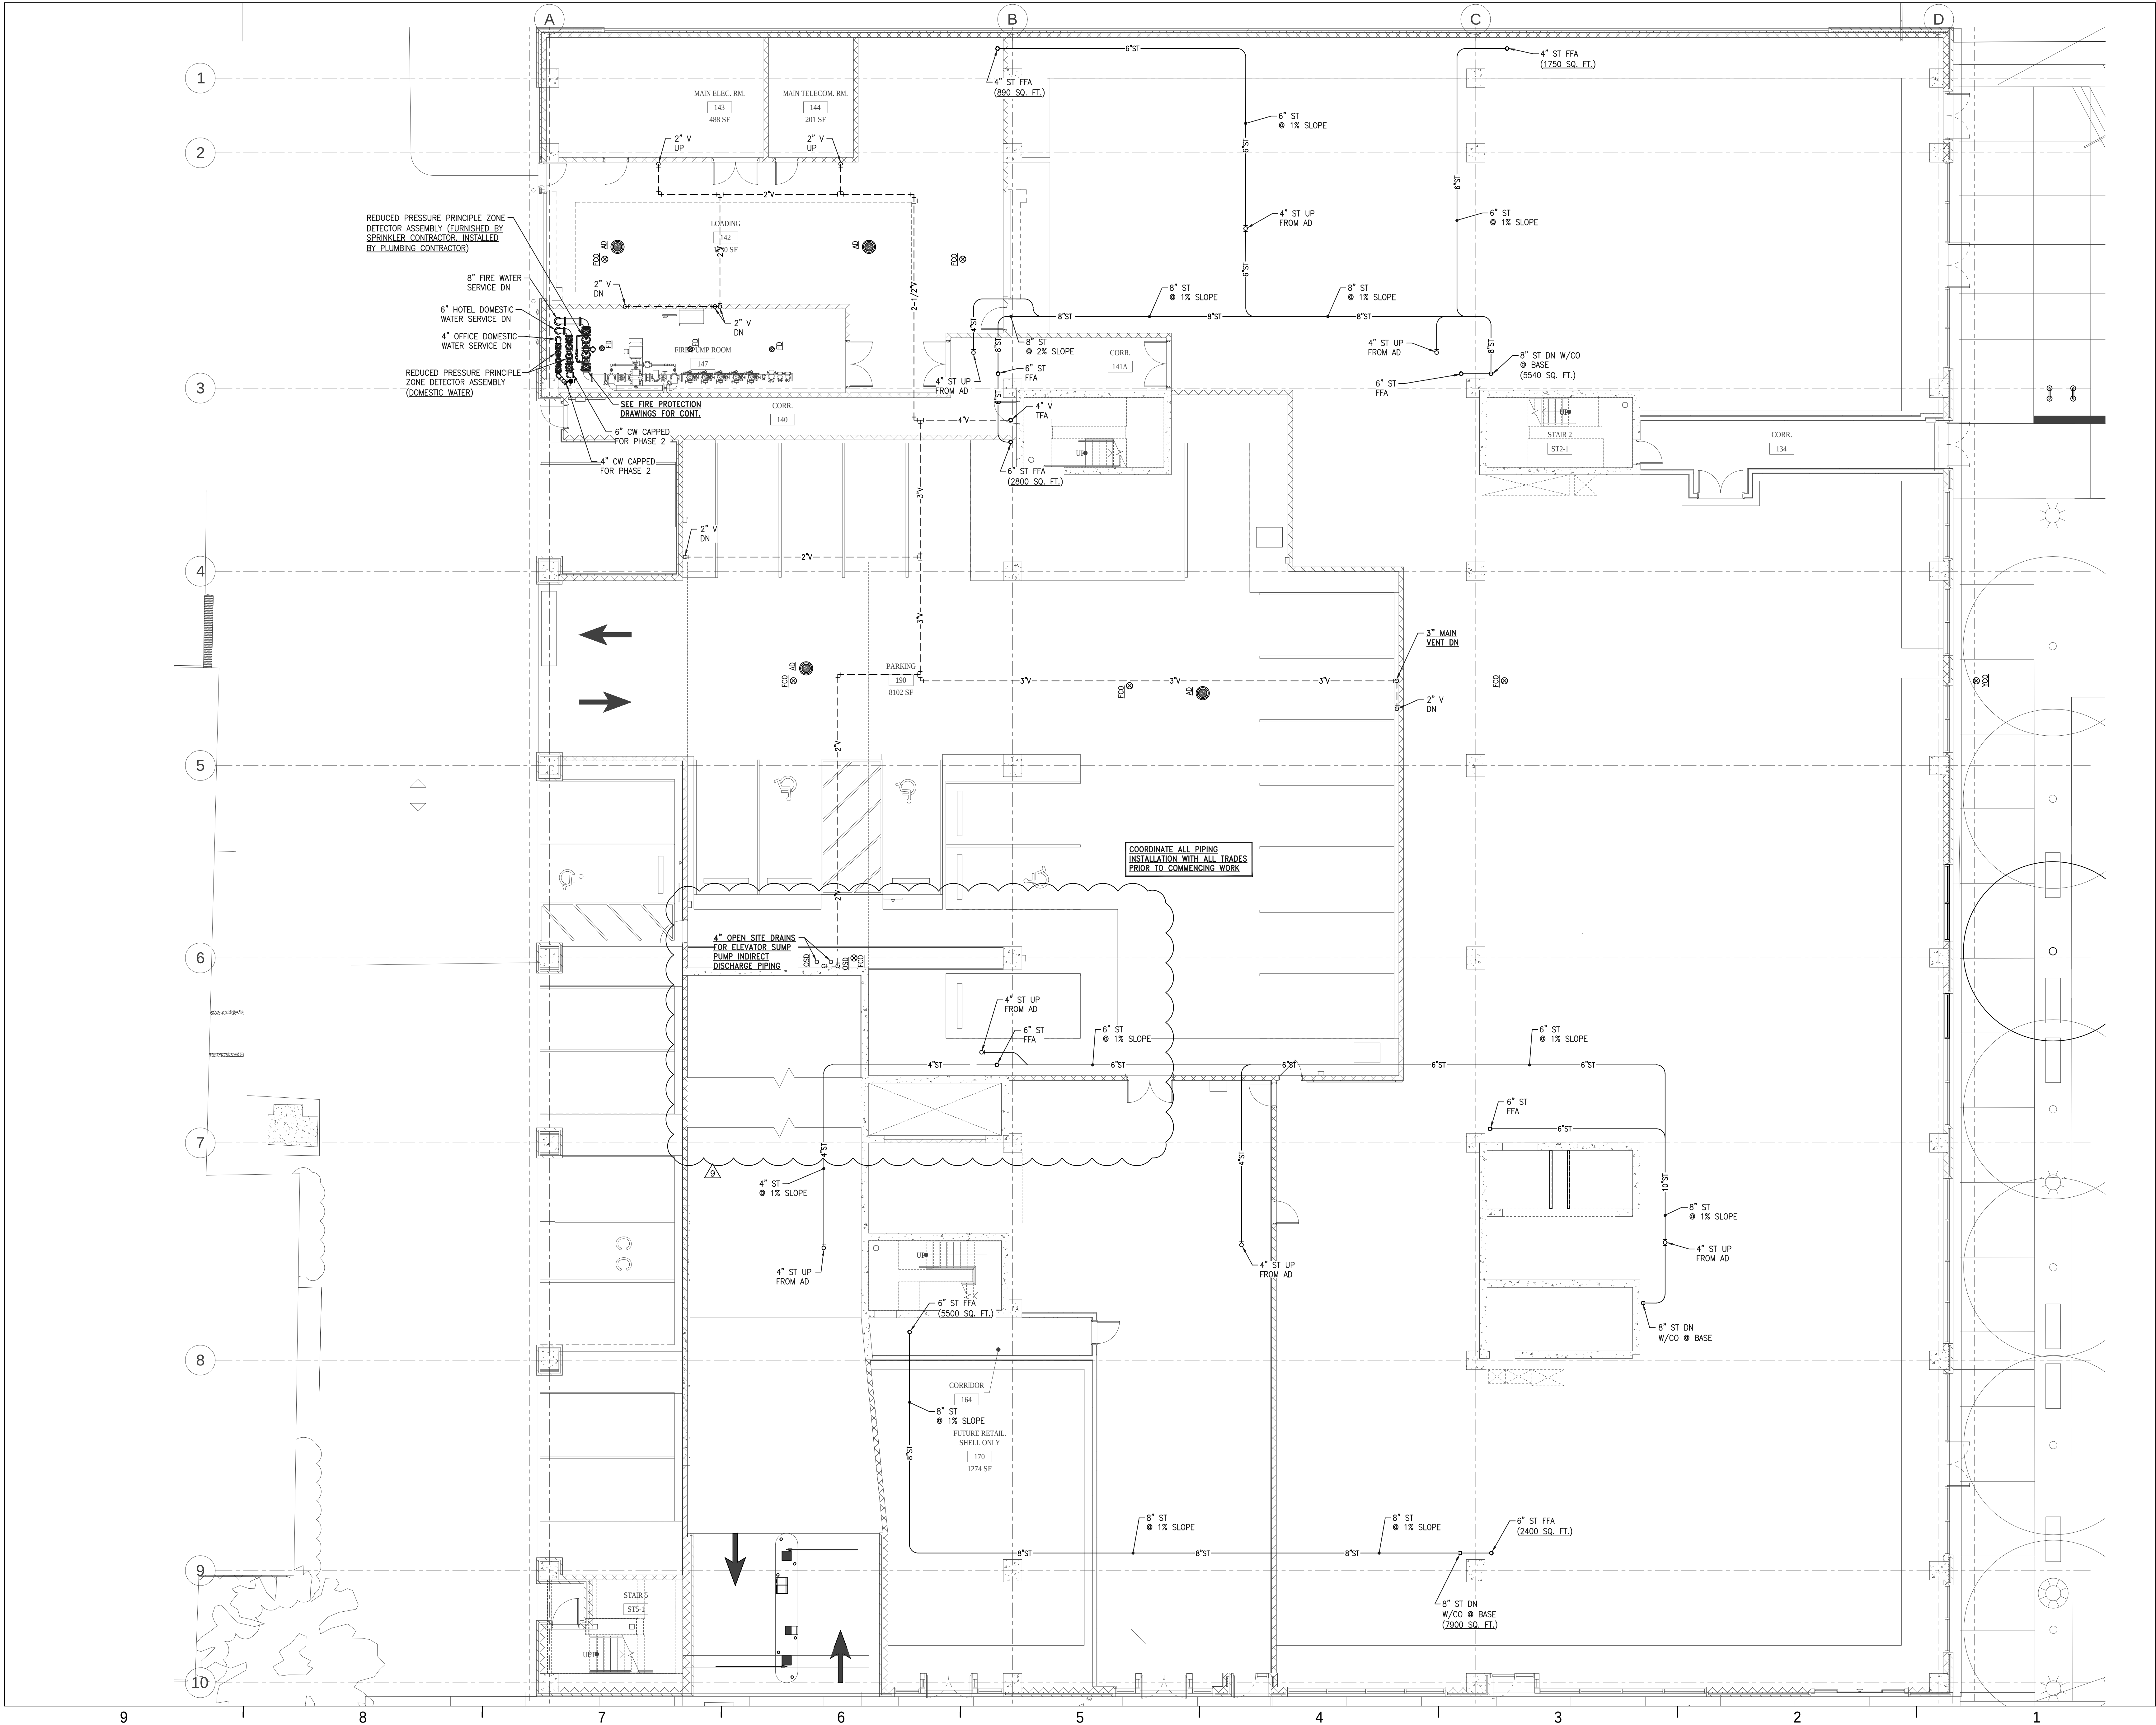



1

2

3

4

5

6


7

8

9

10

9 8 7 6 5 4 3 2 1

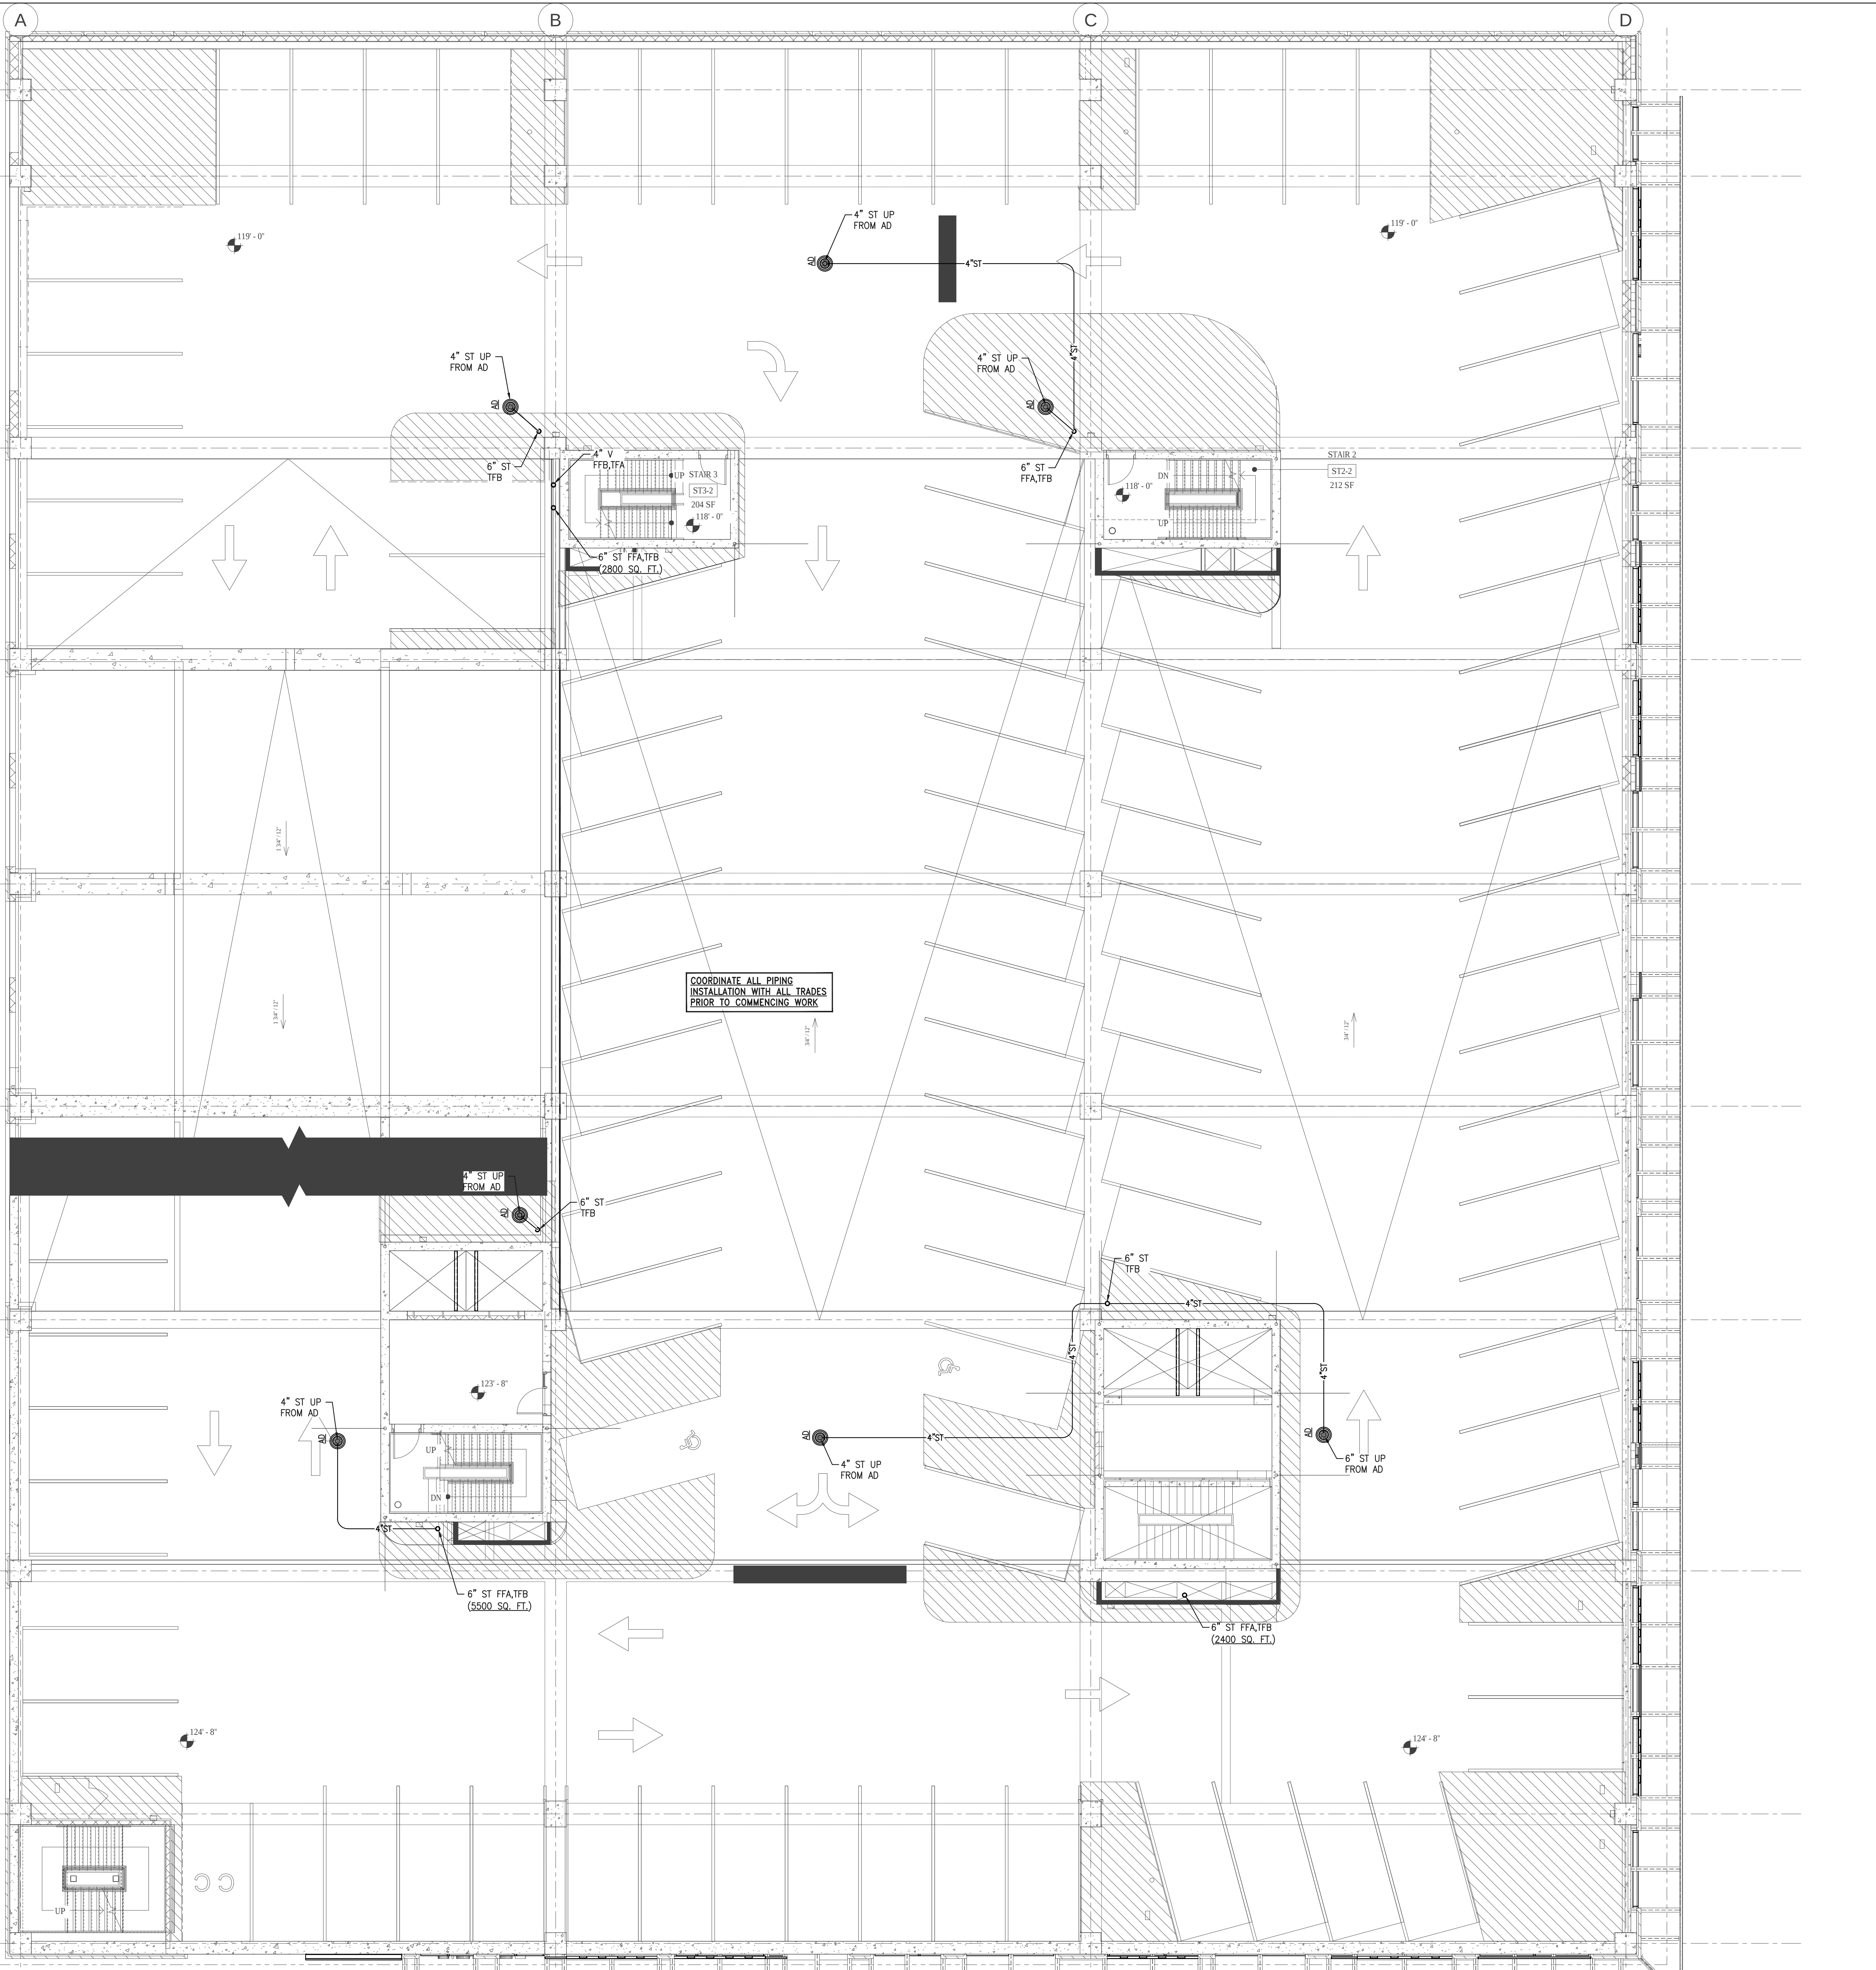

COORDINATE ALL PIPING
INSTALLATION WITH ALL TRADES
PRIOR TO COMMENCING WORK

SCOPE OF DOCUMENT

1. THIS DOCUMENT WITH THE ACCOMPANYING DRAWINGS AND SPECIFICATIONS, DESCRIBES THE GENERAL SCOPE OF THE PROJECT AND DESIGN CONCEPT IN TERMS OF THE ARCHITECTURAL, STRUCTURAL, MECHANICAL AND ELECTRICAL SYSTEMS. THESE DOCUMENTS DO NOT NECESSARILY INDICATE OR DESCRIBE ALL OF THE WORK REQUIRED FOR THE FULL PERFORMANCE AND COMPLETION OF THE REQUIREMENTS OF THE CONTRACT.

2. ON THE BASIS OF THE SCOPE INDICATED OR DESCRIBED, THE CONTRACTOR SHALL DETERMINE AND INCLUDE IN HIS PROPOSALS ALL ITEMS NECESSARY TO PROVIDE THE PROPER EXECUTION AND COMPLETION OF THE WORK.

STAMP

9	PHASE I IFC ADDENDUM	2/20/2019
8	ISSUE FOR REVISIONS	12/6/2018
7	PHASE I CONSTRUCTION	11/2/2018
6	PHASE I (PODIUM) PERMIT REV.	10/12/2018
5	PHASE I (PODIUM) PERMIT REV.	9/21/2018
4	PHASE I (PODIUM) PERMIT REV.	9/7/2018
3	PHASE I (PODIUM) PERMIT	7/17/2018
2	FOUNDATION PERMIT REV	5/3/2018
1	FOUNDATION PERMIT	4/20/2018
NUMBER	ISSUED FOR	DATE

BUILT FORM
ARCHITECTURE 935 W Chestnut St., Ste # 520
Chicago, IL 60642

CLIENT
PRINCE CHARLES HOLDINGS, LLC
PO BOX 650, Durham, NC 27702

CIVIL ENGINEER / LANDSCAPE ARCHITECT
STEWART
421 Fayetteville St., Suite 400, Raleigh, NC 27601

STRUCTURAL ENGINEER
KIMLEY-HORN
421 Fayetteville St., Suite 600, Raleigh, NC 27601

PLANNING CONSULTANT
J TATLOCK DESIGN LLC
11035 Killian Park Road, Miami, FL 33156

MECHANICAL / ELECTRICAL / PLUMBING ENGINEER
ADVANCE CONSULTING GROUP INTERNATIONAL
300 W. Adams Street, Suite 420, Chicago, IL 60606

POOL CONSULTANT
TBD

ACOUSTICAL CONSULTANT
TBD

PROJECT
FAYETTEVILLE MIXED-USE DEVELOPMENT
500 Hay Street, Fayetteville, NC 28301

SHEET TITLE
**GARAGE
2ND FLOOR PLUMBING PLAN**

PROJECT NO.
P103

DATE

©2018 BUILT FORM, LLC



1

2

3

4

5


6

7

8

9

10

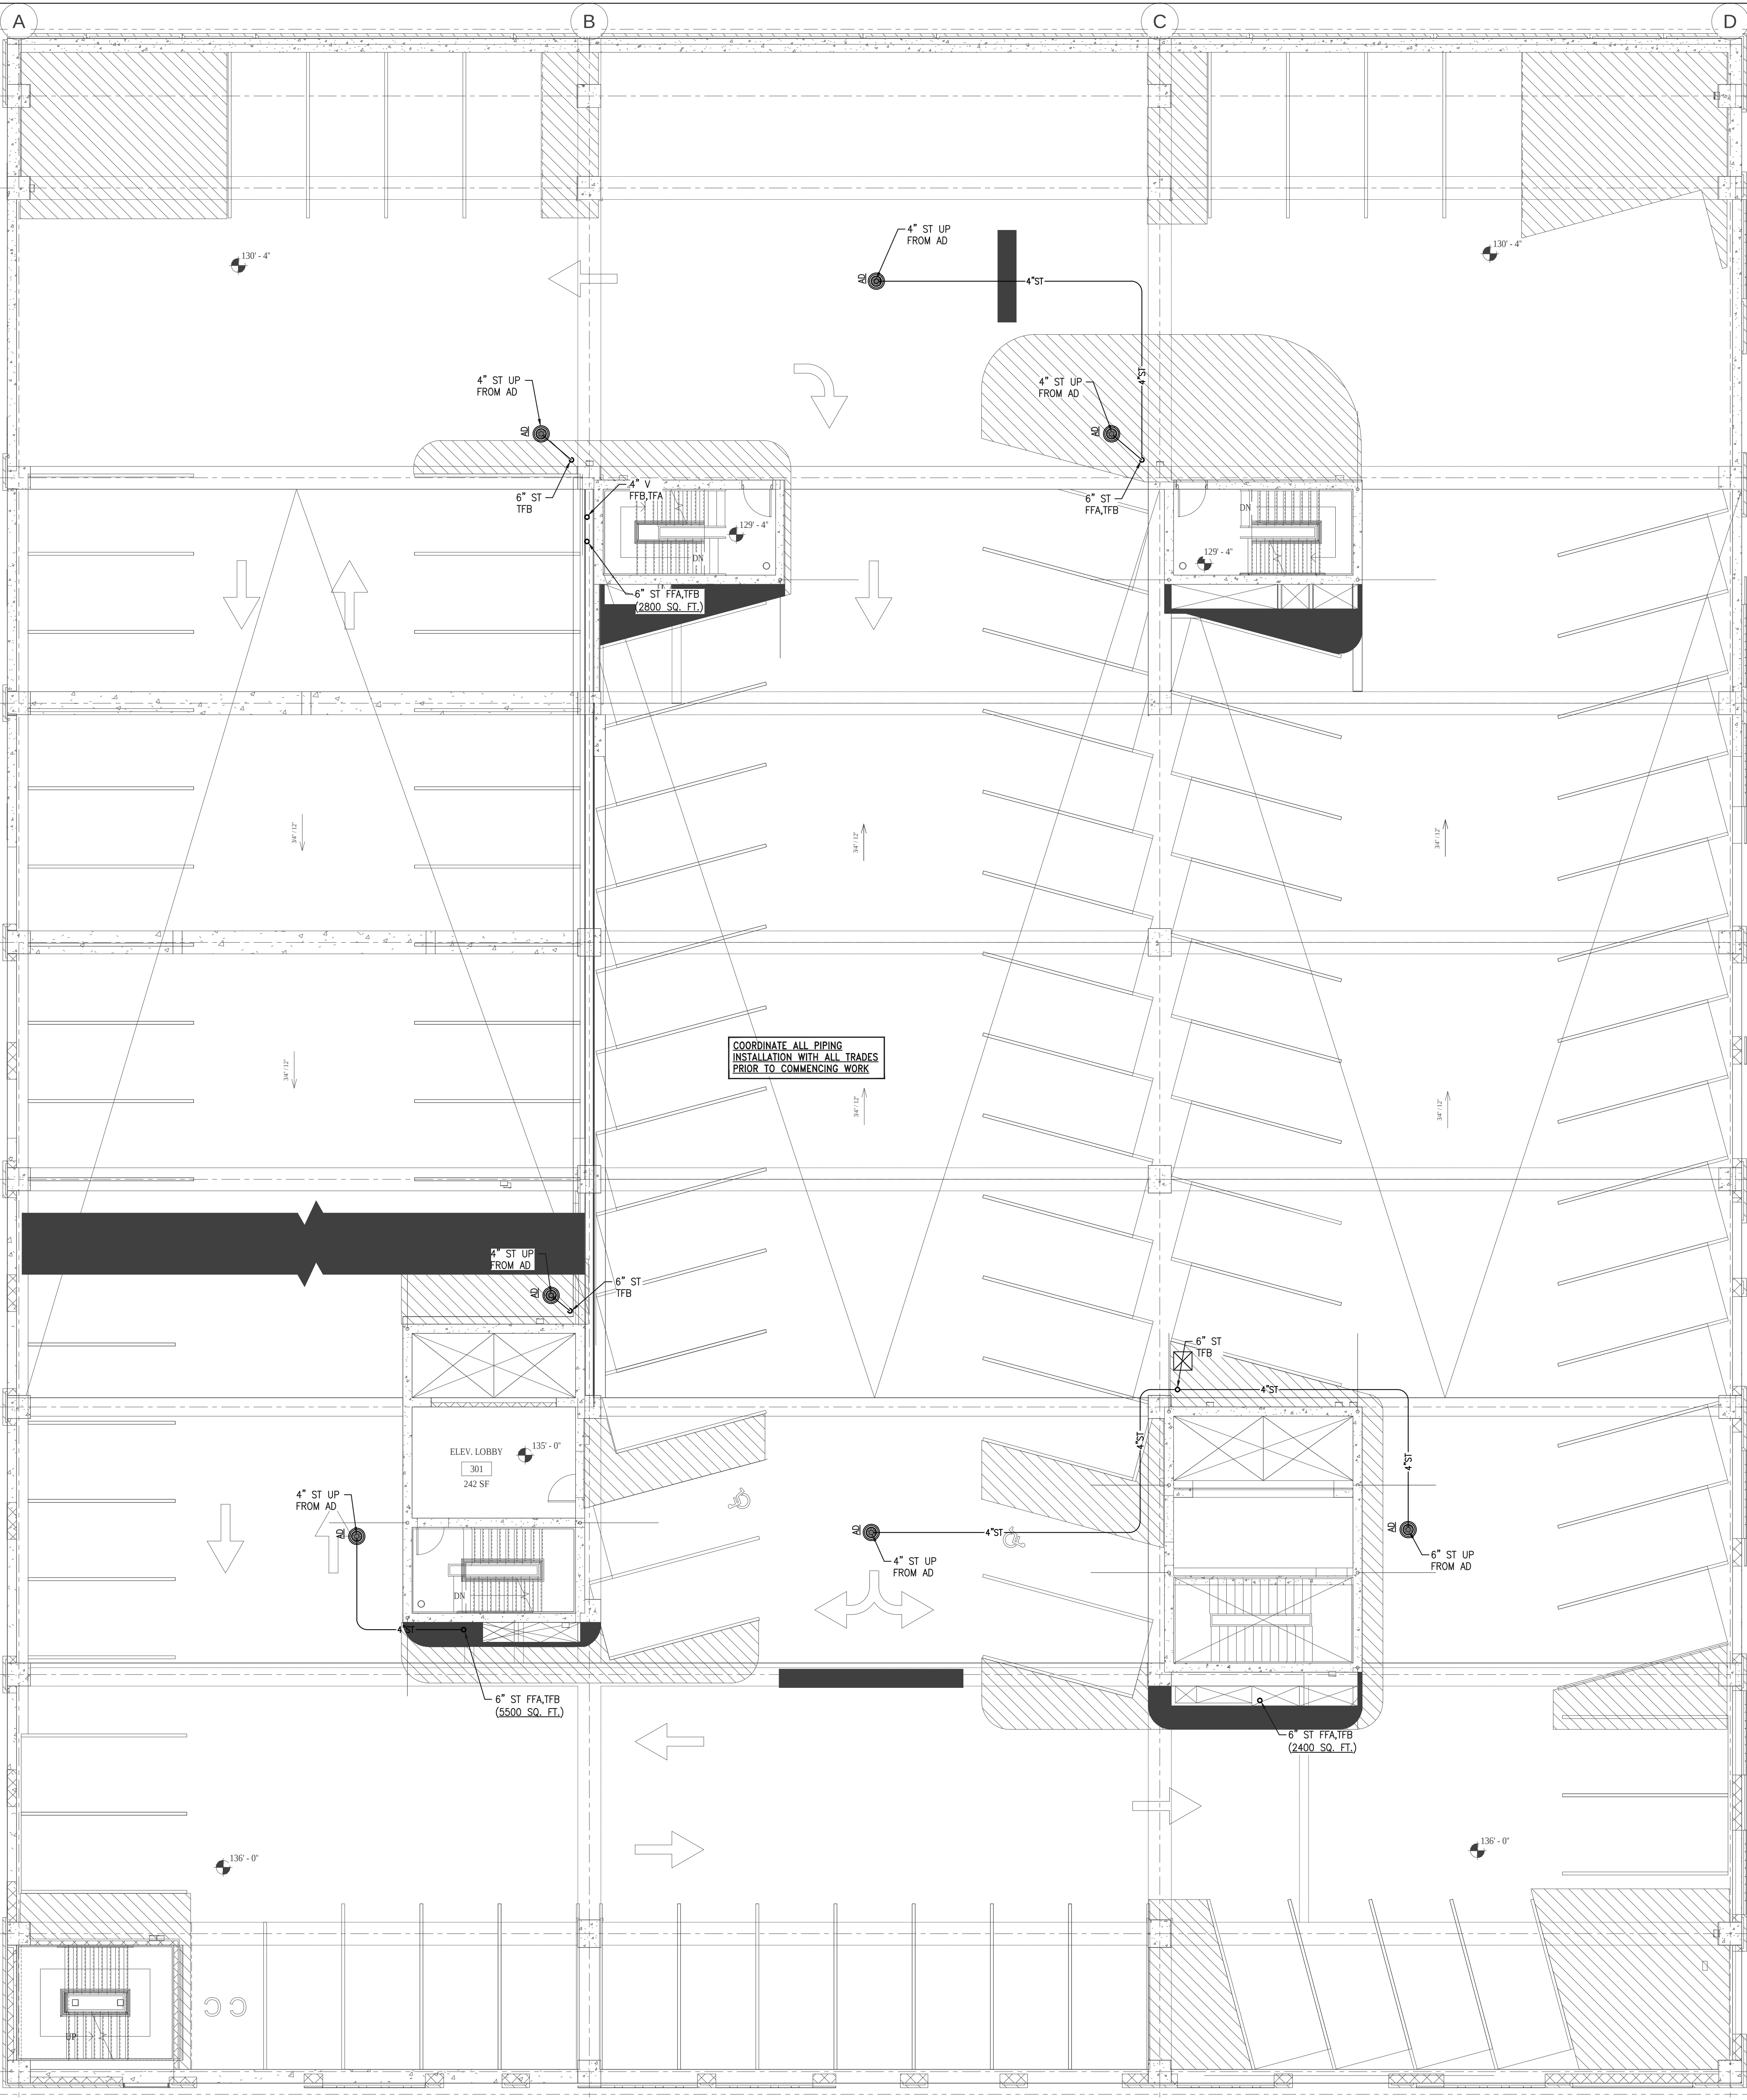

9 8 7 6 5 4 3 2 1

A

B

C

D

E

F

G

H

J

SCOPE OF DOCUMENT

1. THIS DOCUMENT WITH THE ACCOMPANYING DRAWINGS AND SPECIFICATIONS, DESCRIBES THE GENERAL SCOPE OF THE PROJECT AND DESIGN CONCEPT IN TERMS OF THE ARCHITECTURAL, STRUCTURAL, MECHANICAL AND ELECTRICAL SYSTEMS. THESE DOCUMENTS DO NOT NECESSARILY INDICATE OR DESCRIBE ALL OF THE WORK REQUIRED FOR THE FULL PERFORMANCE AND COMPLETION OF THE REQUIREMENTS OF THE CONTRACT.

2. ON THE BASIS OF THE SCOPE INDICATED OR DESCRIBED, THE CONTRACTOR SHALL DETERMINE AND INCLUDE IN HIS PROPOSALS ALL ITEMS NECESSARY TO PROVIDE THE PROPER EXECUTION AND COMPLETION OF THE WORK.

STAMP

NUMBER	ISSUED FOR	DATE
9	PHASE I IFC ADDENDUM	2/20/2019
8	ISSUE FOR REVISIONS	12/6/2018
7	PHASE I CONSTRUCTION	11/2/2018
6	PHASE I (PODIUM) PERMIT REV.	10/12/2018
5	PHASE I (PODIUM) PERMIT REV.	9/21/2018
4	PHASE I (PODIUM) PERMIT REV.	9/7/2018
3	PHASE I (PODIUM) PERMIT	7/17/2018
2	FOUNDATION PERMIT REV	5/3/2018
1	FOUNDATION PERMIT	4/20/2018

BUILT FORM
ARCHITECTURE 935 W Chestnut St., Ste # 520
Chicago, IL 60642

CLIENT
PRINCE CHARLES HOLDINGS, LLC
PO BOX 650, Durham, NC 27702

CIVIL ENGINEER / LANDSCAPE ARCHITECT
STEWART
421 Fayetteville St., Suite 400, Raleigh, NC 27601

STRUCTURAL ENGINEER
KIMLEY-HORN
421 Fayetteville St., Suite 600, Raleigh, NC 27601

PLANNING CONSULTANT
J TATLOCK DESIGN LLC
11035 Killian Park Road, Miami, FL 33156

MECHANICAL / ELECTRICAL / PLUMBING ENGINEER
ADVANCE CONSULTING GROUP INTERNATIONAL
300 W. Adams Street, Suite 420, Chicago, IL 60606

POOL CONSULTANT
TBD

ACOUSTICAL CONSULTANT
TBD

PROJECT
FAYETTEVILLE MIXED-USE DEVELOPMENT
500 Hay Street, Fayetteville, NC 28301

SHEET TITLE
**GARAGE
3RD FLOOR PLUMBING PLAN**

PROJECT NO.
P104

DATE

©2018 BUILT FORM, LLC



1

2

3

4

5


6

7

8

9

10

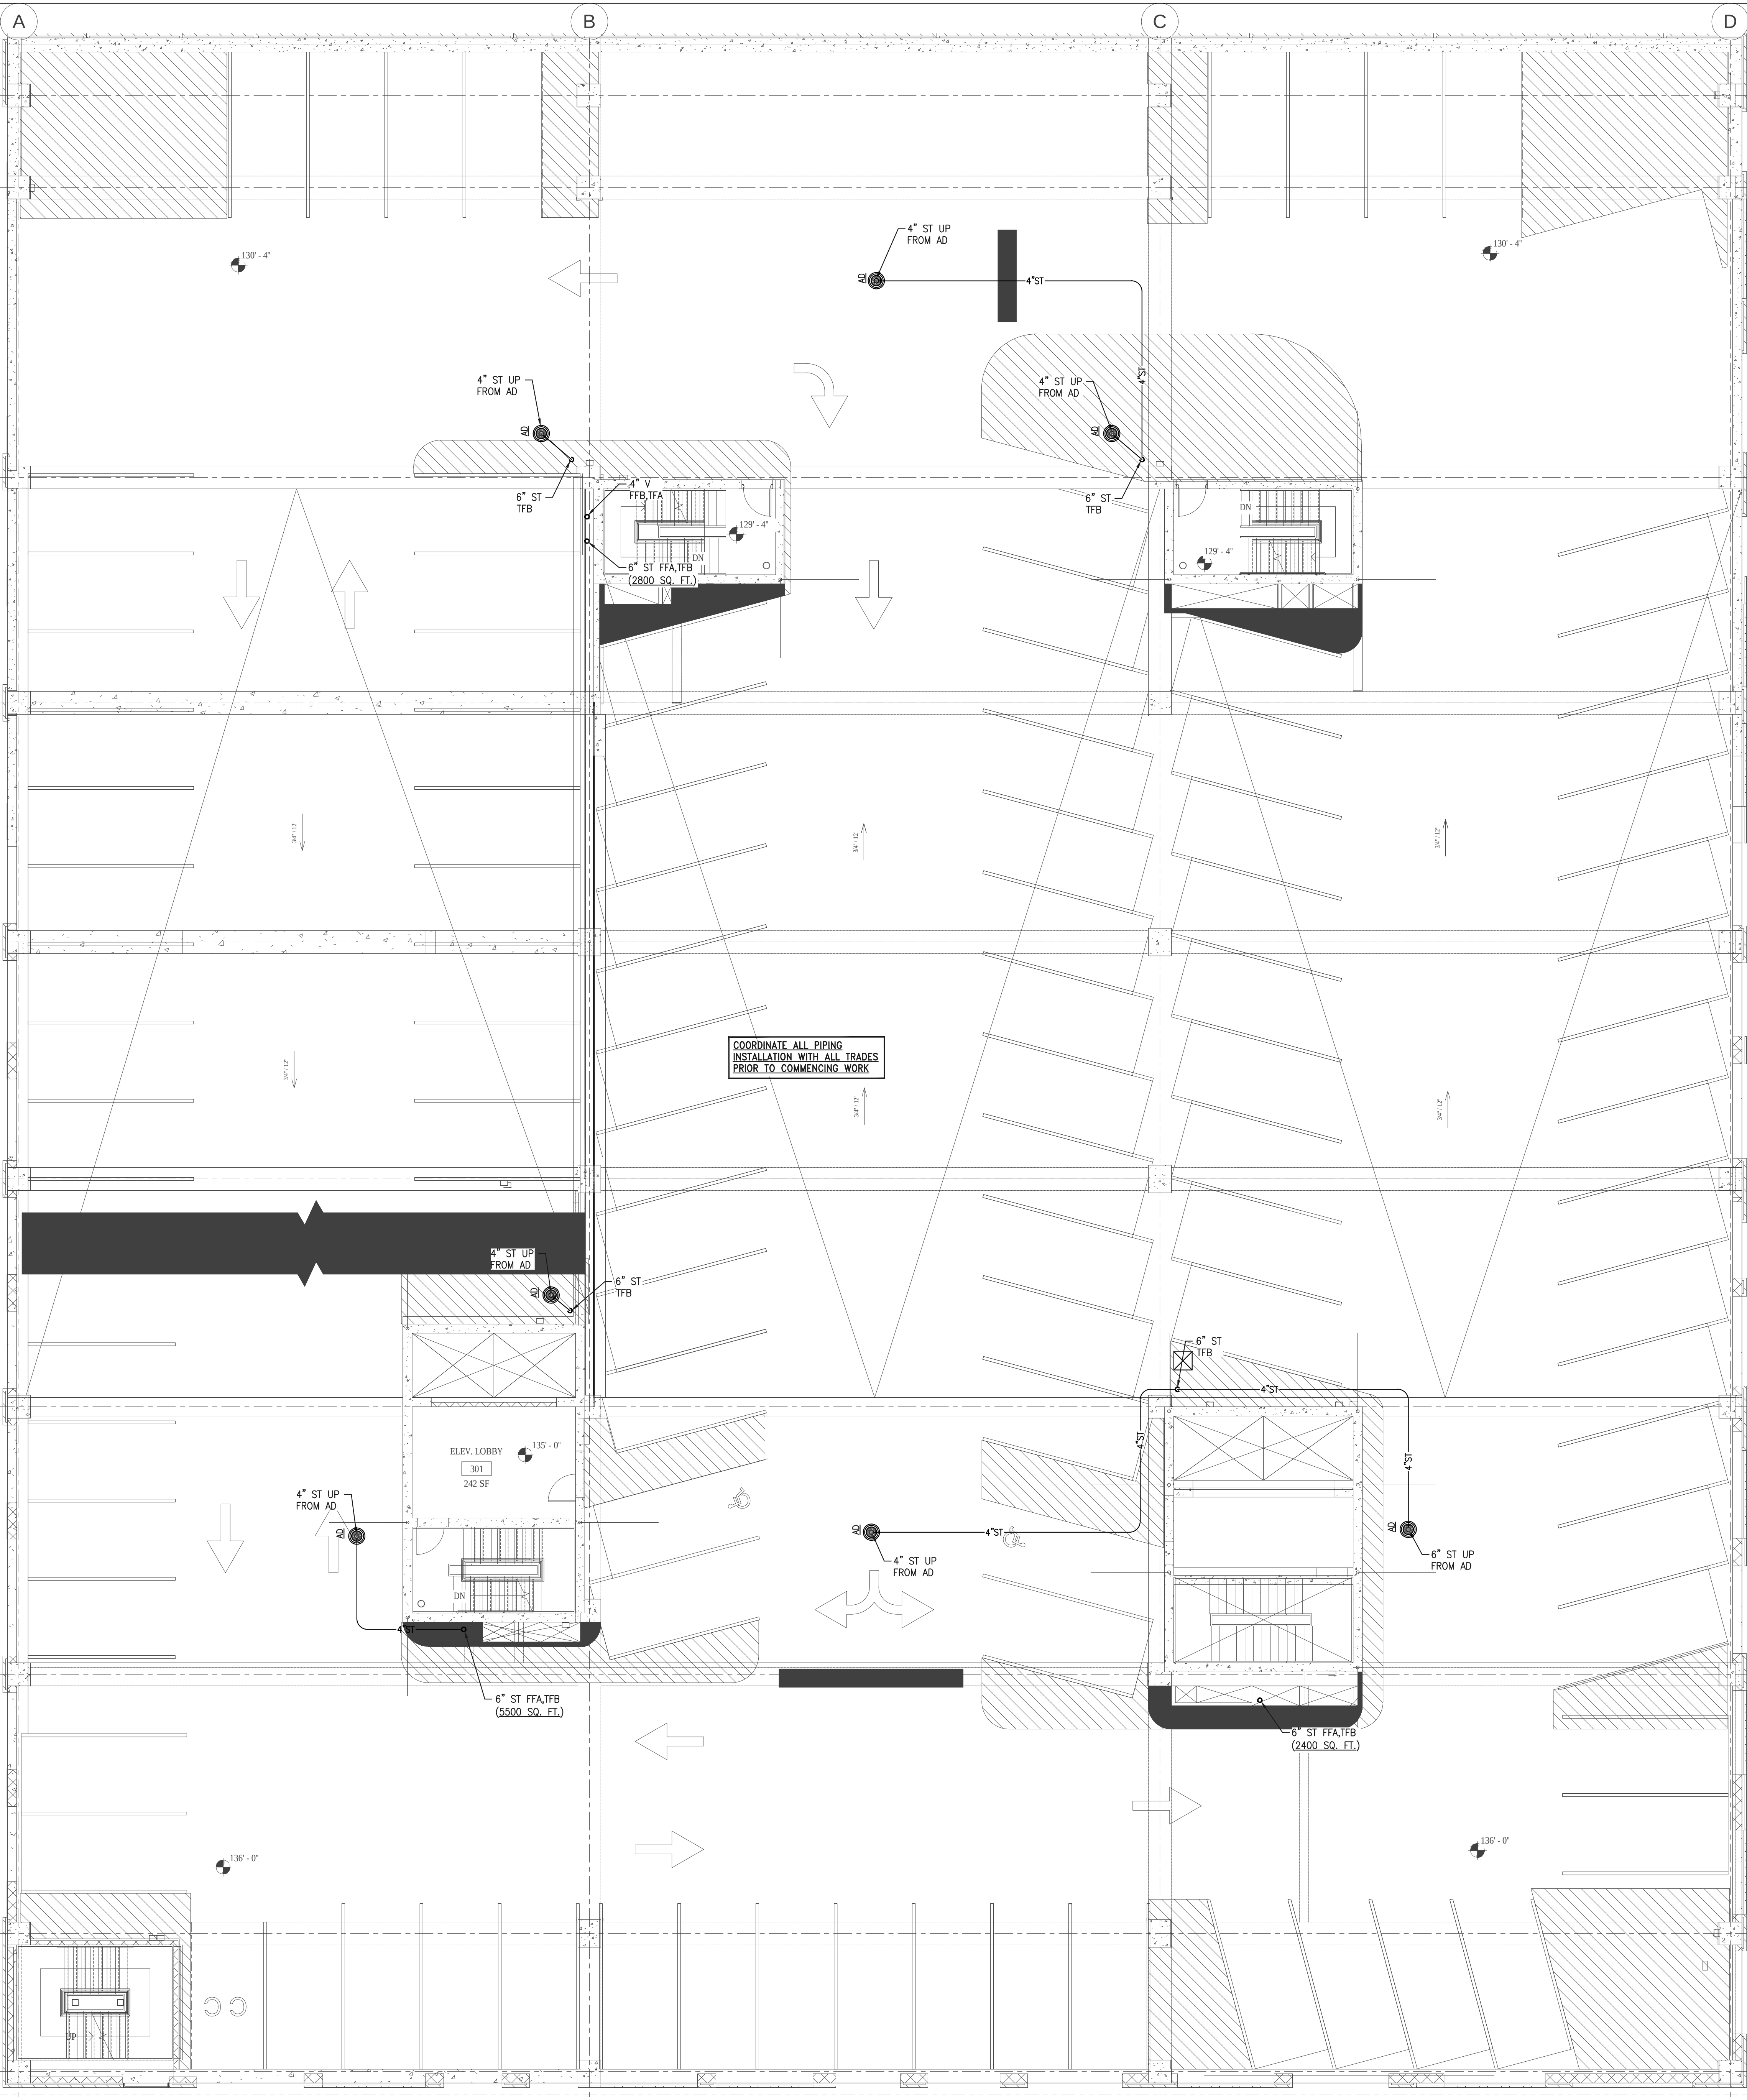

COORDINATE ALL PIPING
INSTALLATION WITH ALL TRADES
PRIOR TO COMMENCING WORK

A

B

C

D

E

F

G

H

J

SCOPE OF DOCUMENT

1. THIS DOCUMENT WITH THE ACCOMPANYING DRAWINGS AND SPECIFICATIONS, DESCRIBES THE GENERAL SCOPE OF THE PROJECT AND DESIGN CONCEPT IN TERMS OF THE ARCHITECTURAL, STRUCTURAL, MECHANICAL AND ELECTRICAL SYSTEMS. THESE DOCUMENTS DO NOT NECESSARILY INDICATE OR DESCRIBE ALL OF THE WORK REQUIRED FOR THE FULL PERFORMANCE AND COMPLETION OF THE REQUIREMENTS OF THE CONTRACT.

2. ON THE BASIS OF THE SCOPE INDICATED OR DESCRIBED, THE CONTRACTOR SHALL DETERMINE AND INCLUDE IN HIS PROPOSALS ALL ITEMS NECESSARY TO PROVIDE THE PROPER EXECUTION AND COMPLETION OF THE WORK.

STAMP

9	PHASE I IFC ADDENDUM	2/20/2019
8	ISSUE FOR REVISIONS	12/6/2018
7	PHASE I CONSTRUCTION	11/2/2018
6	PHASE I (PODIUM) PERMIT REV.	10/12/2018
5	PHASE I (PODIUM) PERMIT REV.	9/21/2018
4	PHASE I (PODIUM) PERMIT REV.	9/7/2018
3	PHASE I (PODIUM) PERMIT	7/17/2018
2	FOUNDATION PERMIT REV	5/3/2018
1	FOUNDATION PERMIT	4/20/2018
NUMBER	ISSUED FOR	DATE

BUILT FORM
ARCHITECTURE 935 W Chestnut St., Ste # 520
Chicago, IL 60642

CLIENT
PRINCE CHARLES HOLDINGS, LLC
PO BOX 650, Durham, NC 27702

CIVIL ENGINEER / LANDSCAPE ARCHITECT
STEWART
421 Fayetteville St., Suite 400, Raleigh, NC 27601

STRUCTURAL ENGINEER
KIMLEY-HORN
421 Fayetteville St., Suite 600, Raleigh, NC 27601

PLANNING CONSULTANT
J TATLOCK DESIGN LLC
11035 Killian Park Road, Miami, FL 33156

MECHANICAL / ELECTRICAL / PLUMBING ENGINEER
ADVANCE CONSULTING GROUP INTERNATIONAL
300 W. Adams Street, Suite 420, Chicago, IL 60606

POOL CONSULTANT
TBD

ACOUSTICAL CONSULTANT
TBD

PROJECT
FAYETTEVILLE MIXED-USE DEVELOPMENT
500 Hay Street, Fayetteville, NC 28301

SHEET TITLE
**GARAGE
4TH FLOOR PLUMBING PLAN**

PROJECT NO.
P105

DATE

©2018 BUILT FORM, LLC



1. THIS DOCUMENT WITH THE ACCOMPANYING DRAWINGS AND SPECIFICATIONS, DESCRIBES THE GENERAL SCOPE OF THE PROJECT AND DESIGN CONCEPT IN TERMS OF THE ARCHITECTURAL, STRUCTURAL, MECHANICAL AND ELECTRICAL SYSTEMS. THESE DOCUMENTS DO NOT NECESSARILY INDICATE OR DESCRIBE ALL OF THE WORK REQUIRED FOR THE FULL PERFORMANCE AND COMPLETION OF THE REQUIREMENTS OF THE CONTRACT.
2. ON THE BASIS OF THE SCOPE INDICATED OR DESCRIBED, THE CONTRACTOR SHALL DETERMINE AND INCLUDE IN HIS PROPOSALS ALL ITEMS NECESSARY TO PROVIDE THE PROPER EXECUTION AND COMPLETION OF THE WORK.

B U I L T F O R M
ARCHITECTURE 935 W Chestnut St., Ste # 520
Chicago, IL 60642

PROJECT
FAYETTEVILLE MIXED-USE DEVELOPMENT
500 Hay Street, Fayetteville, NC 28301

SHEET TITLE

**GARAGE
5TH FLOOR PLUMBING PLAN**

PROJECT NO.	P106
DATE	